

NOTES:
-ALL WATER RETICULATION PIPES ARE Ø180, PE-100, AND CLASS 'PN16'

LEGEND

FIRE HYDRANT
STOP VALVE
TAPPING BAND
WATER METER
END CAP
TEE
REDUCER

REDUCER
BEND
WATER MAIN

REGISTERED SURVEYOR'S CERTIFICATION

LandPartners Pty Ltd hereby certify that the vertical and horizontal locations and dimensions shown on this plan are a true and correct record and were located by survey.

C Walters

LandPartners Pty Ltd, Reg. Surveyor No. S4118

## ENGINEER'S CERTIFICATION

, ....., hereby certify that:


- The information contained in this drawing / document is in compliance with approved drawings and design.
- 2. The new water and sewerage works defined by this drawing have been
- designed and constructed in accordance with the SEQ Code.
- This represents an accurate record of as-constructed works.
  I accept responsibility for the information contained in this drawing / document.

RPEQ (signature)

RPEQ No.\_\_\_\_\_

Date: .....

Date: 18/07/2023

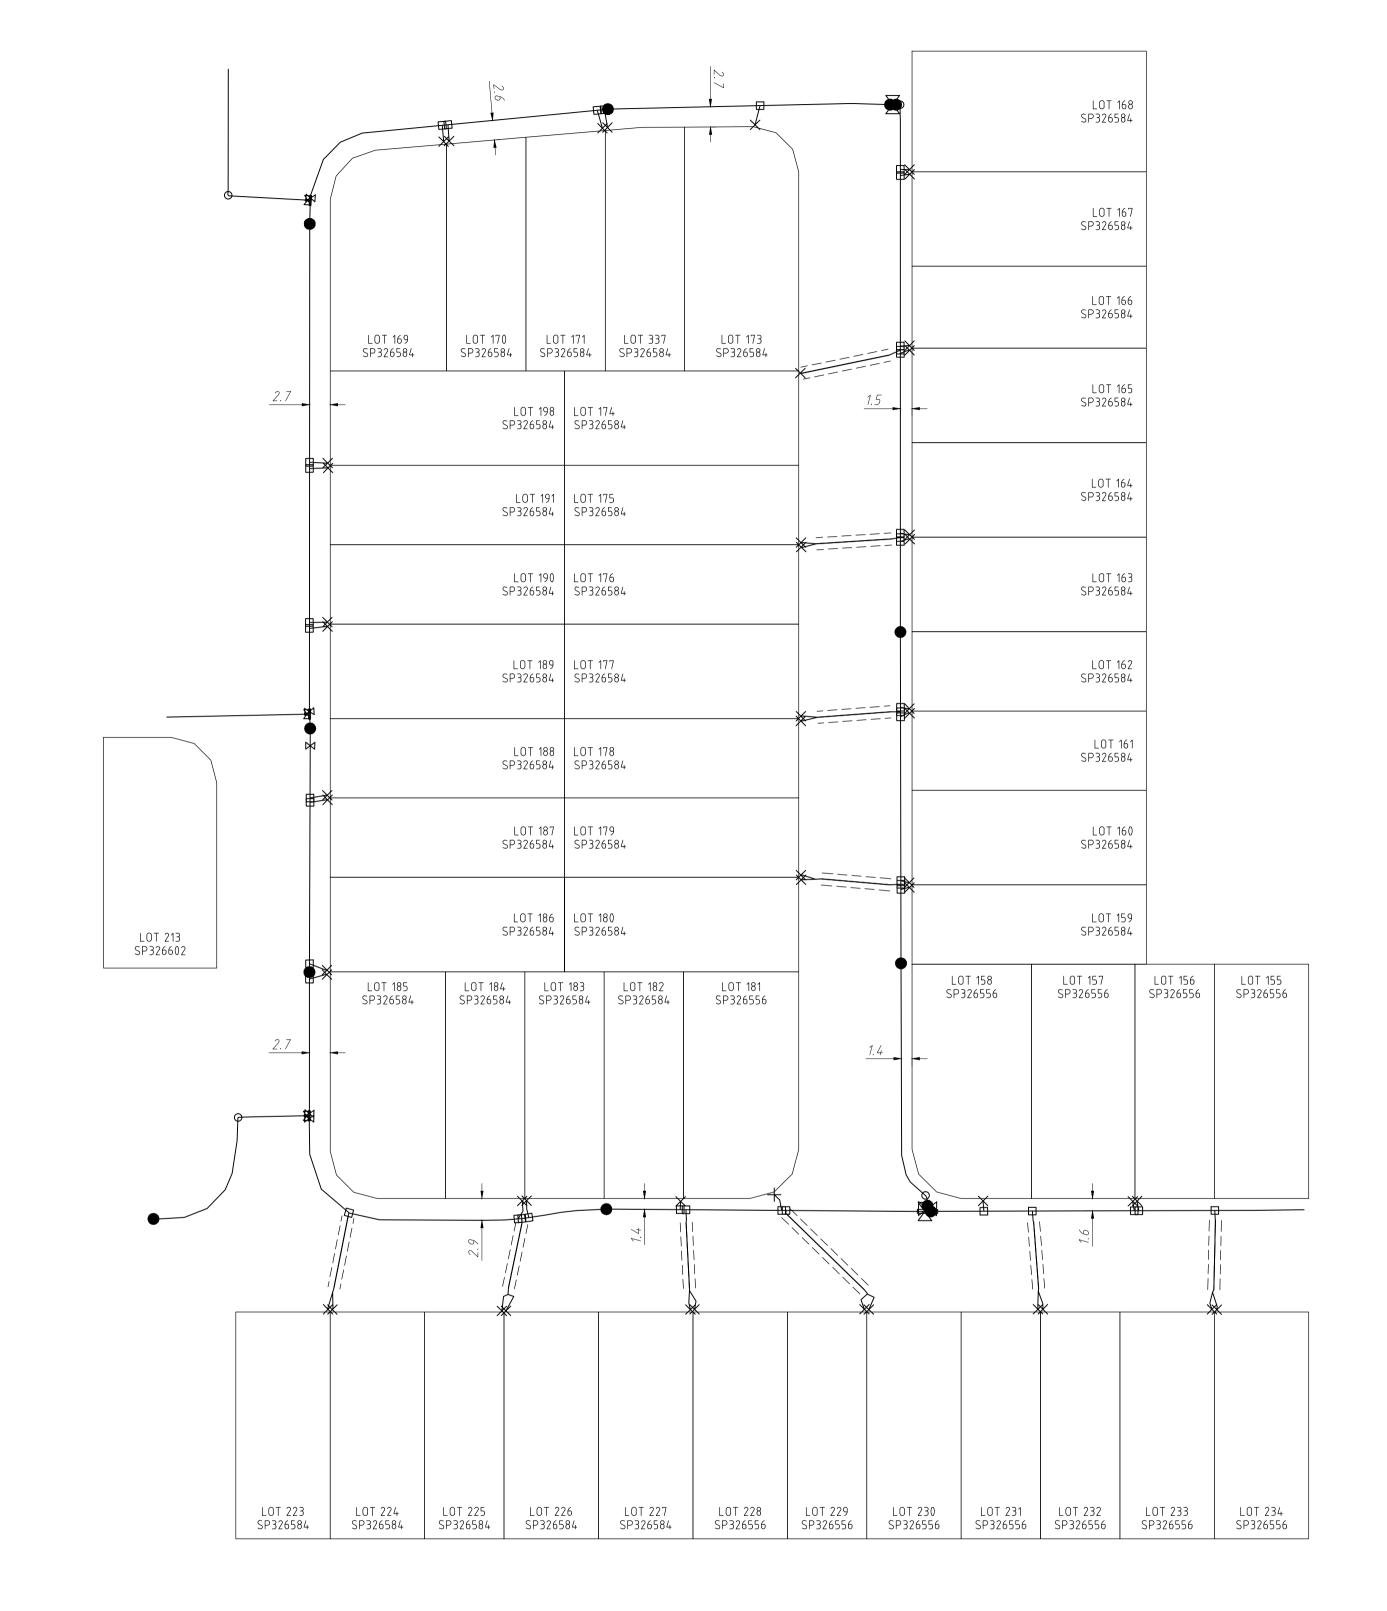

## AS CONSTRUCTED

1:500 10 20 30 ALL DISTANCES IN METRES

									ALL DISTANCES IN METRES
								Queensland Urban Utilities	SCALE 1:500
<b>A1</b>					Brisbane Office Level 1	Queensiand Orban Offices	SHEET 1 OF 1 SHEETS		
				DRAWN	V0	18/07/2023	18 Little Cribb Street Milton Qld 4064 p: (07) 3842 1000 PO Box 1399 e: info@landpartners.com.au  QUEENSLAND	224 250 MONTEDEA DO DOSCINCE O CELACICA ED 8 4	DRAWING NO.
				CHECKED	) RA	18/07/2023	surveyors and planners by Wilton Qid 4064 w: www.landpartners.com.au	236-350 MONTEREA RD PRECINCT 2 - STAGES 5B & 6 AS CONSTRUCTED WATER 21-PNT-53396	
	1 18/07/2023	INITIAL ISSUE	VO RA CW	PASSED	CW	18/07/2023	SSI SO 9017 SO 450017 ASPUZZ SO 450017 A		BRSS6904-005-80-1
	INDEX DATE	REVISIONS	DRAWN CHECKED PASSED		INITIALS	DATE	CERTIFIED CERTIFIED CERTIFIED	21-1 141-33370	